

DON PASQUALE

An opera buffa in three acts by Gaetano Donizetti

Libretto by Gaetano Donizetti and Giovanni Ruffini, after Angelo Anelli's libretto for Pavesi's Ser Marcantonio

Original Production 2011



Richard Hubert Smith

CREATIVE TEAM

Director: Mariame Clément

Designer: Julia Hansen

Lighting Designer: Bernd Purkrabek

CHORUS BREAKDOWN

9 Sopranos
9 Mezzos
9 Tenors
9 Basses
1 Actor (female)

TECHNICAL PERSONNEL

10 Stage Crew
2 Automation
6 Stage Managers
3 Lighting Crew
7 Running Wigs
5 Make-Up
2 Running Wardrobe
8 Dressers


SPECIAL EFFECTS

Revolving stage
Flown pigeon
Bubble machine (for the bath)

TRANSPORT

4 High Cube Containers or
4 Megacube Trailers



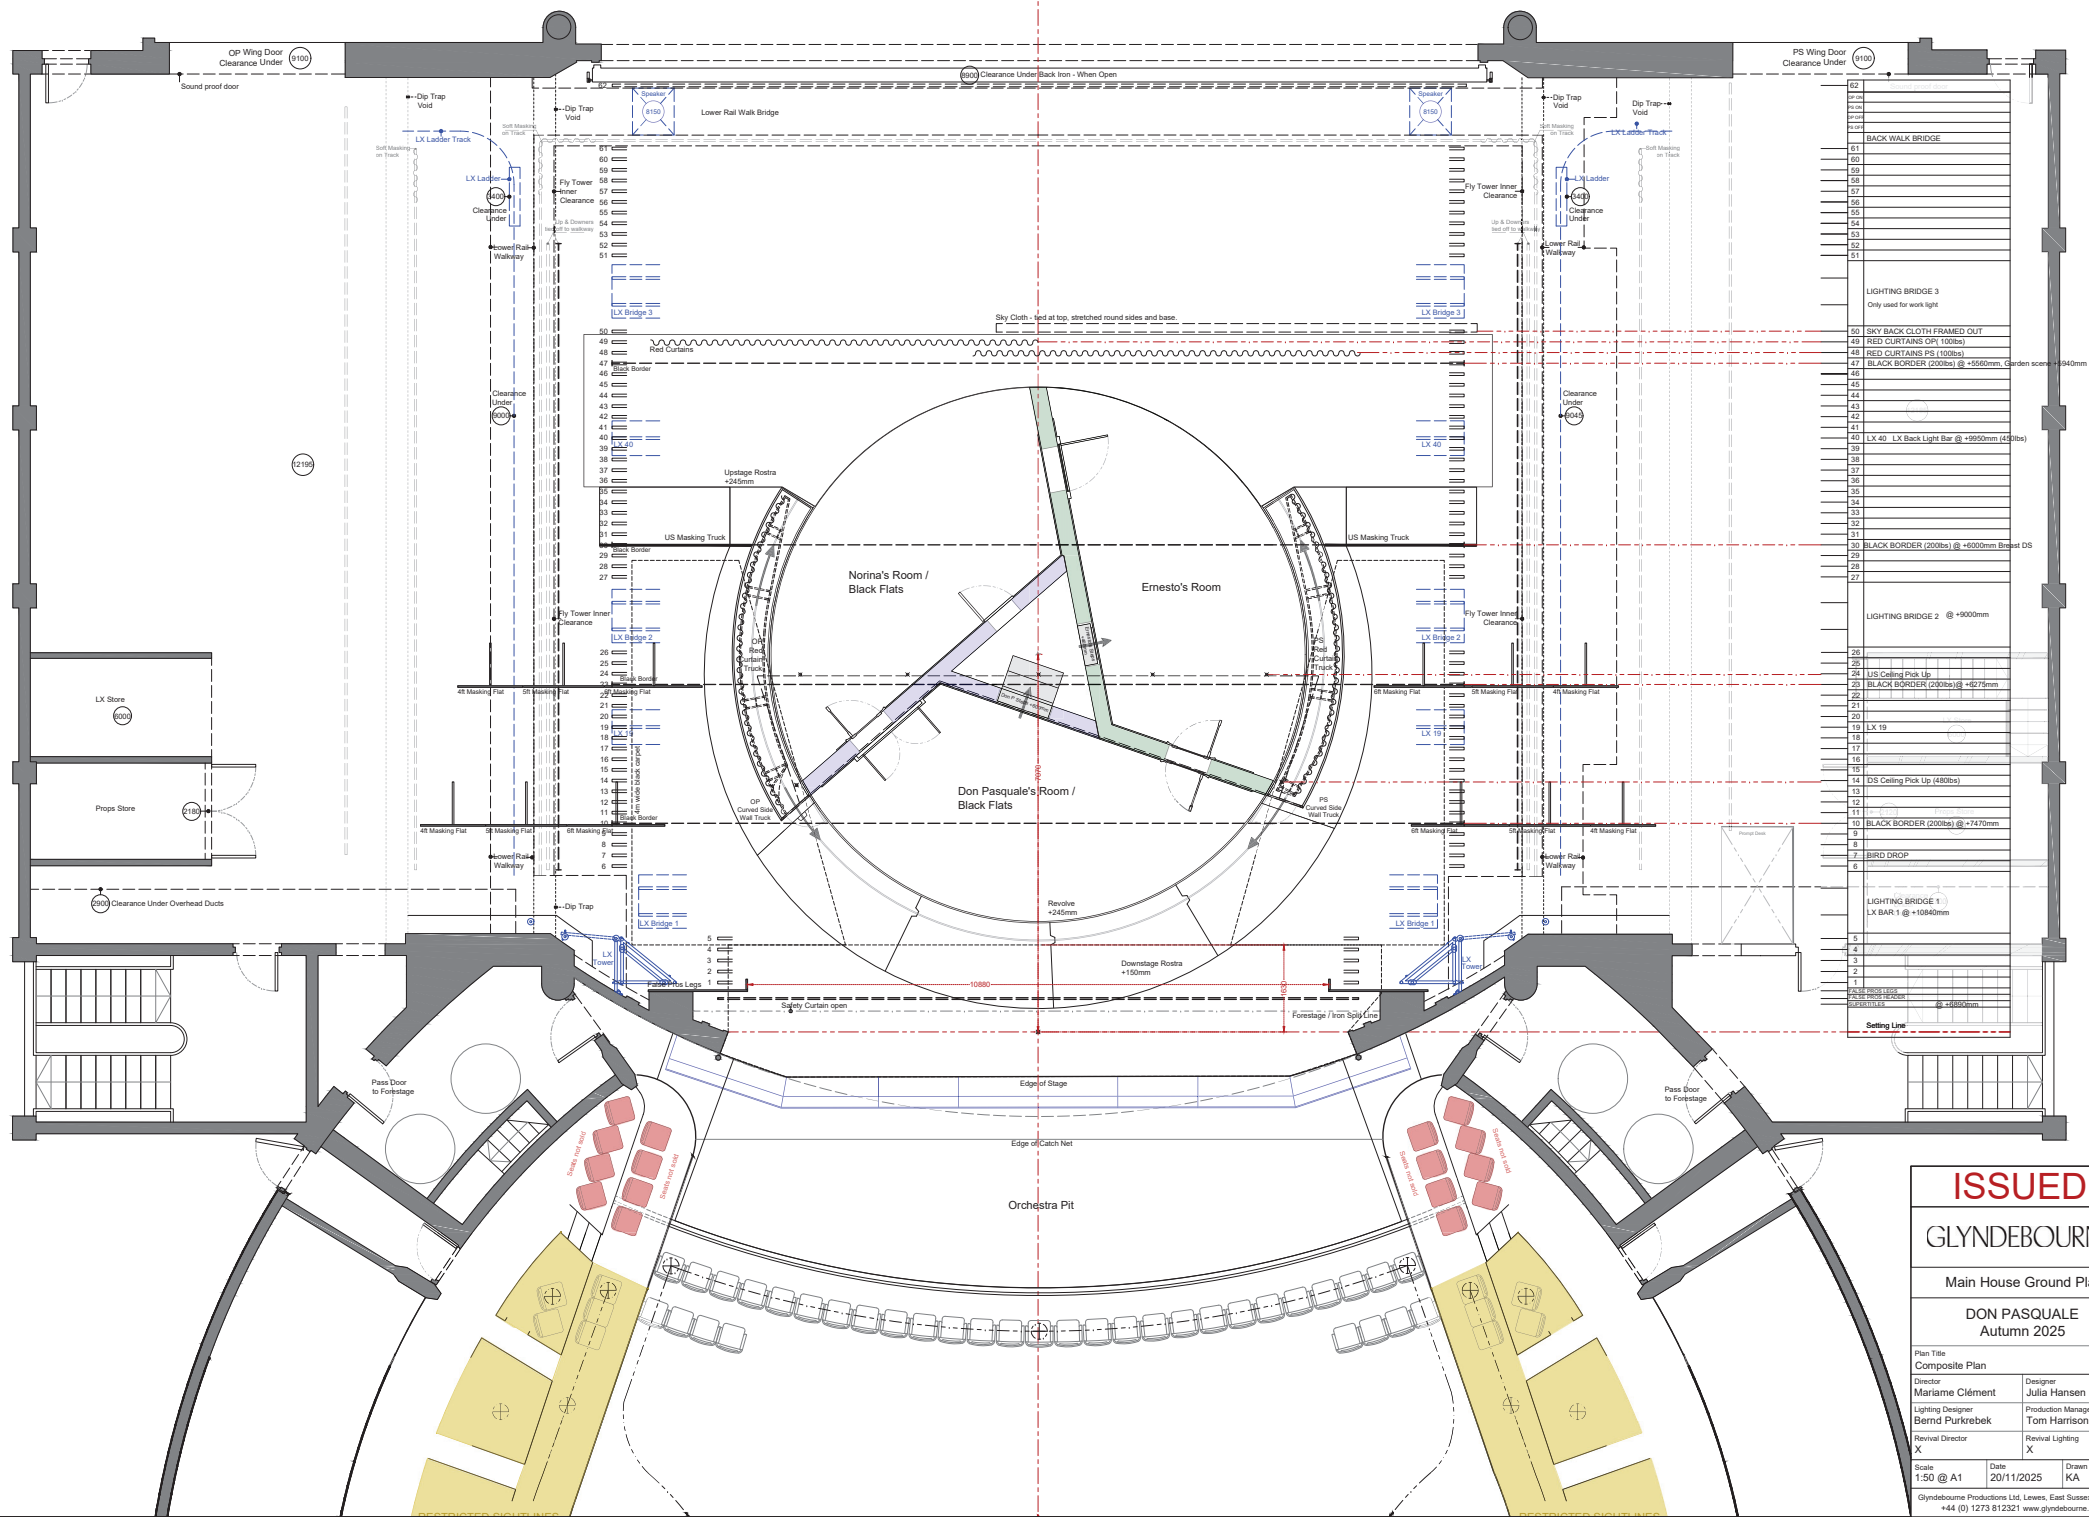

ISSUED

GLYNDEBOURNE

Main House Ground Plan

DON PASQUALE
Autumn 2025

Plan Title
Composite Plan

Director
Maritime Clément

Lighting Designer
Bernd Purkrekrek

Revival Director
X

Designer
Julia Hansen

Production Manager
Tom Harrison


Revival Lighting
X

Scale
1:50 @ A1

Date
20/11/2025

Drawn By
KA

Glyndebourne Productions Ltd, Lewes, East Sussex, BN9 5UJ
+44 (0) 1273 812321 www.glyndebourne.com

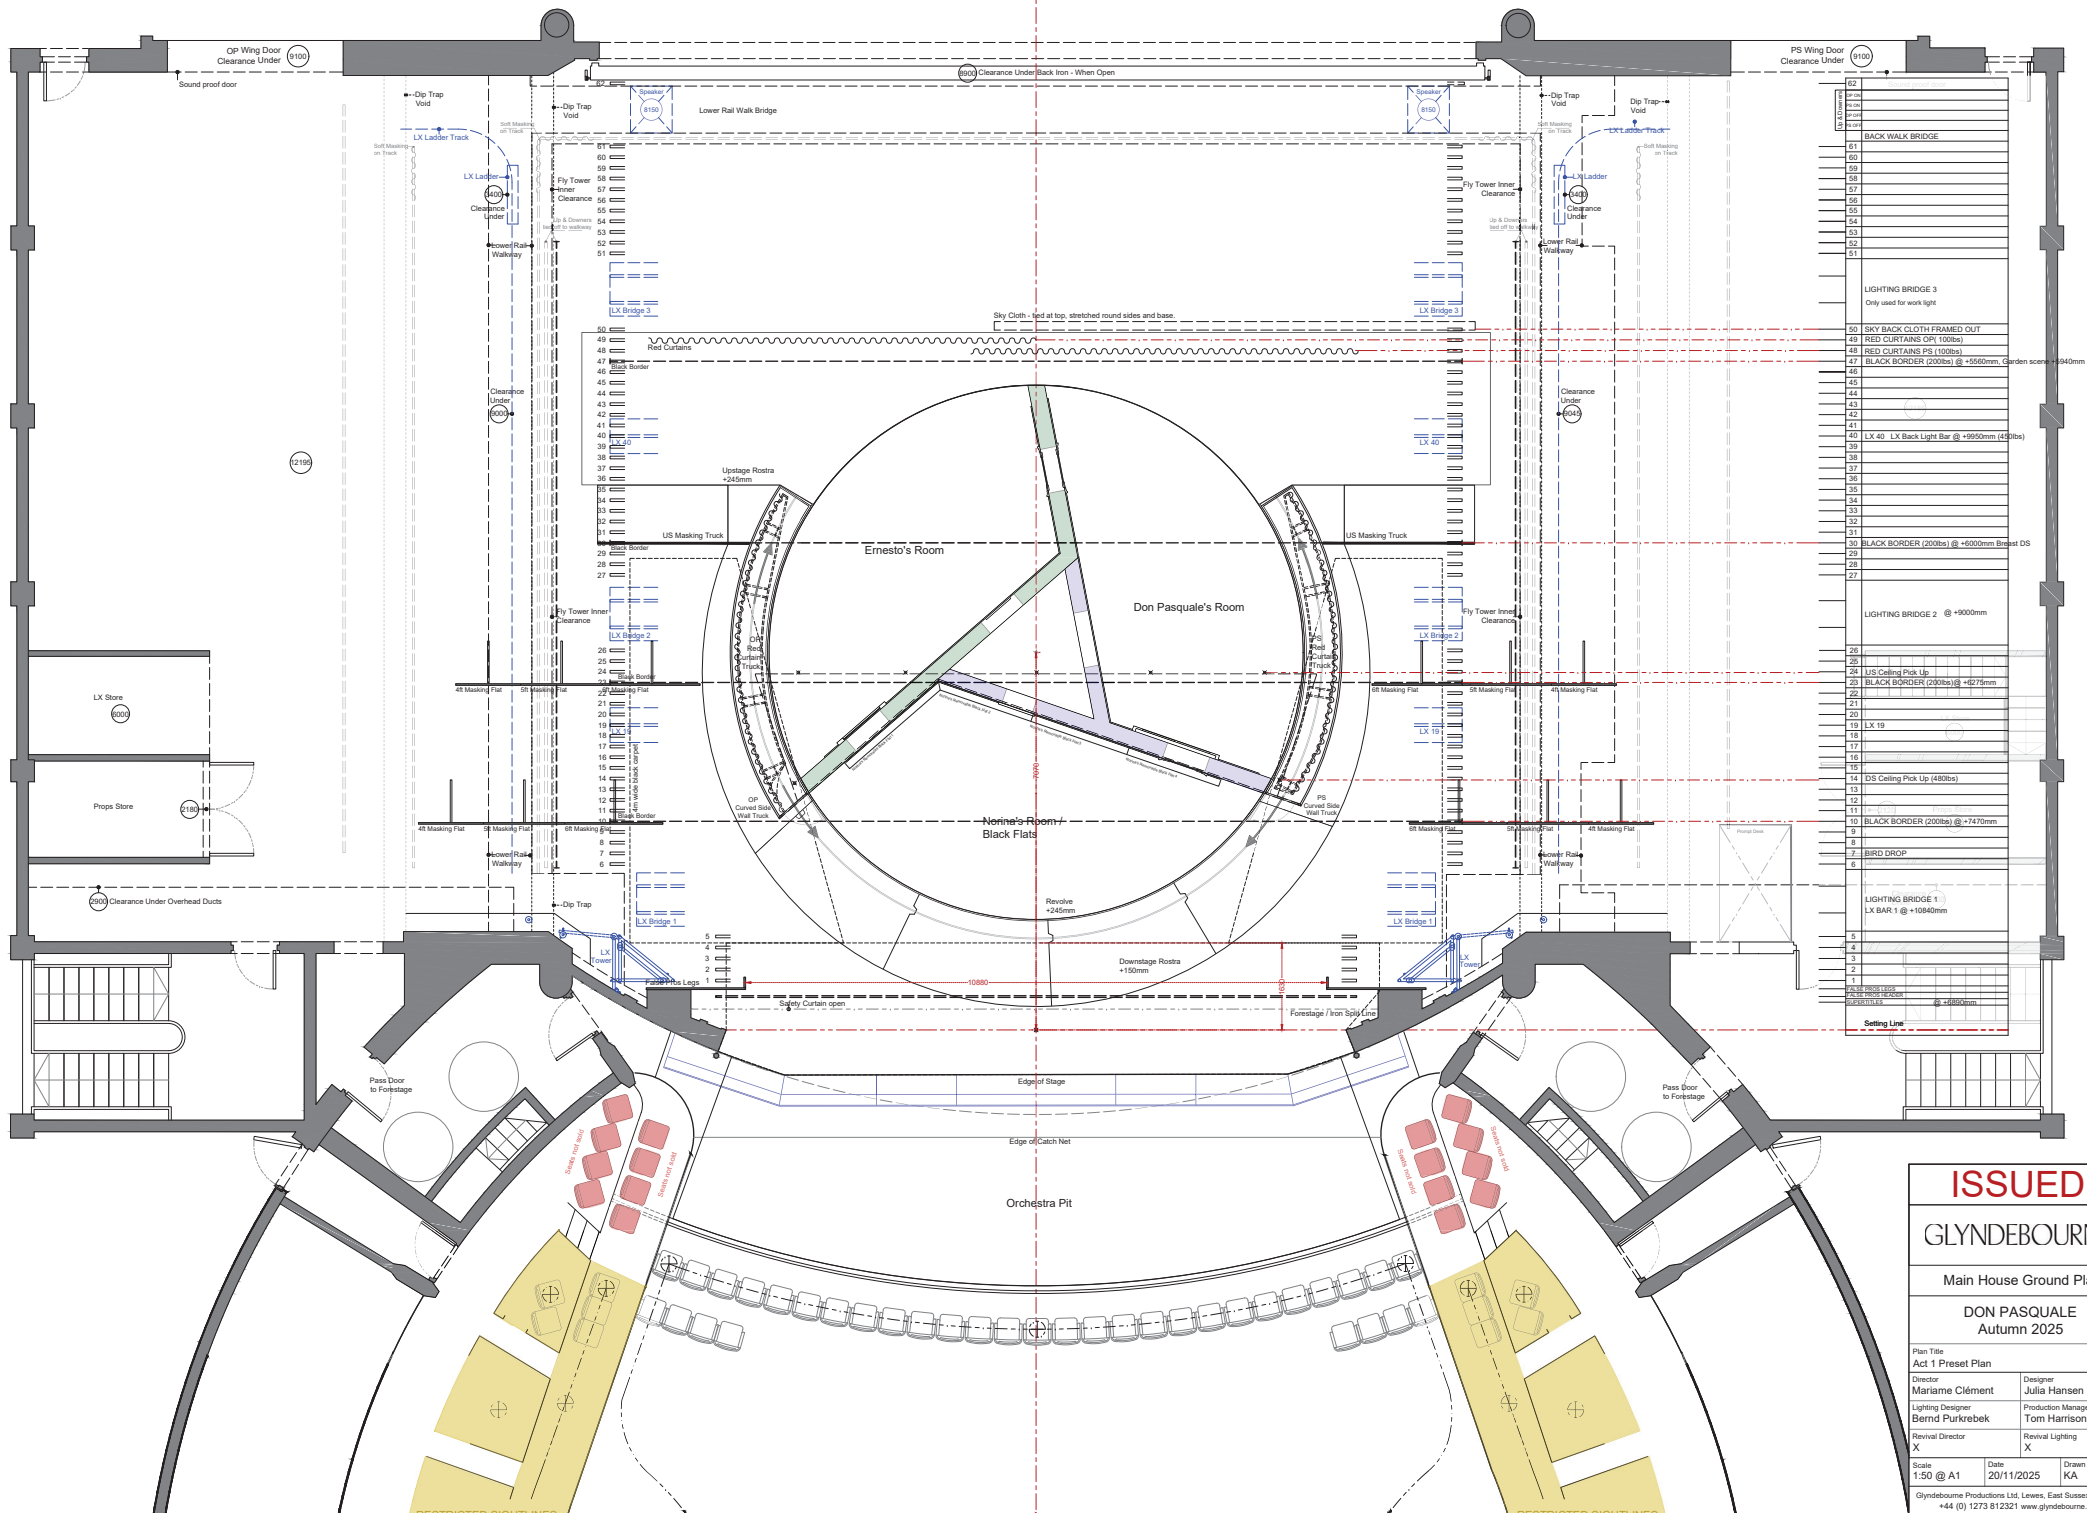

ISSUED

GLYNDEBOURNE

Main House Ground Plan

DON PASQUALE
Autumn 2025

Plan Title
Act 1 Preset Plan

Director
Mariame Clément

Lighting Designer
Bernd Purkrebek

Revival Director
X

Designer
Julia Hansen

Production Manager
Tom Harrison


Revival Lighting
X

Scale
1:50 @ A1

Date
20/11/2025

Drawn By
KA

Glyndebourne Productions Ltd, Lewes, East Sussex, BN9 5UJ
+44 (0) 1273 812321 www.glyndebourne.com

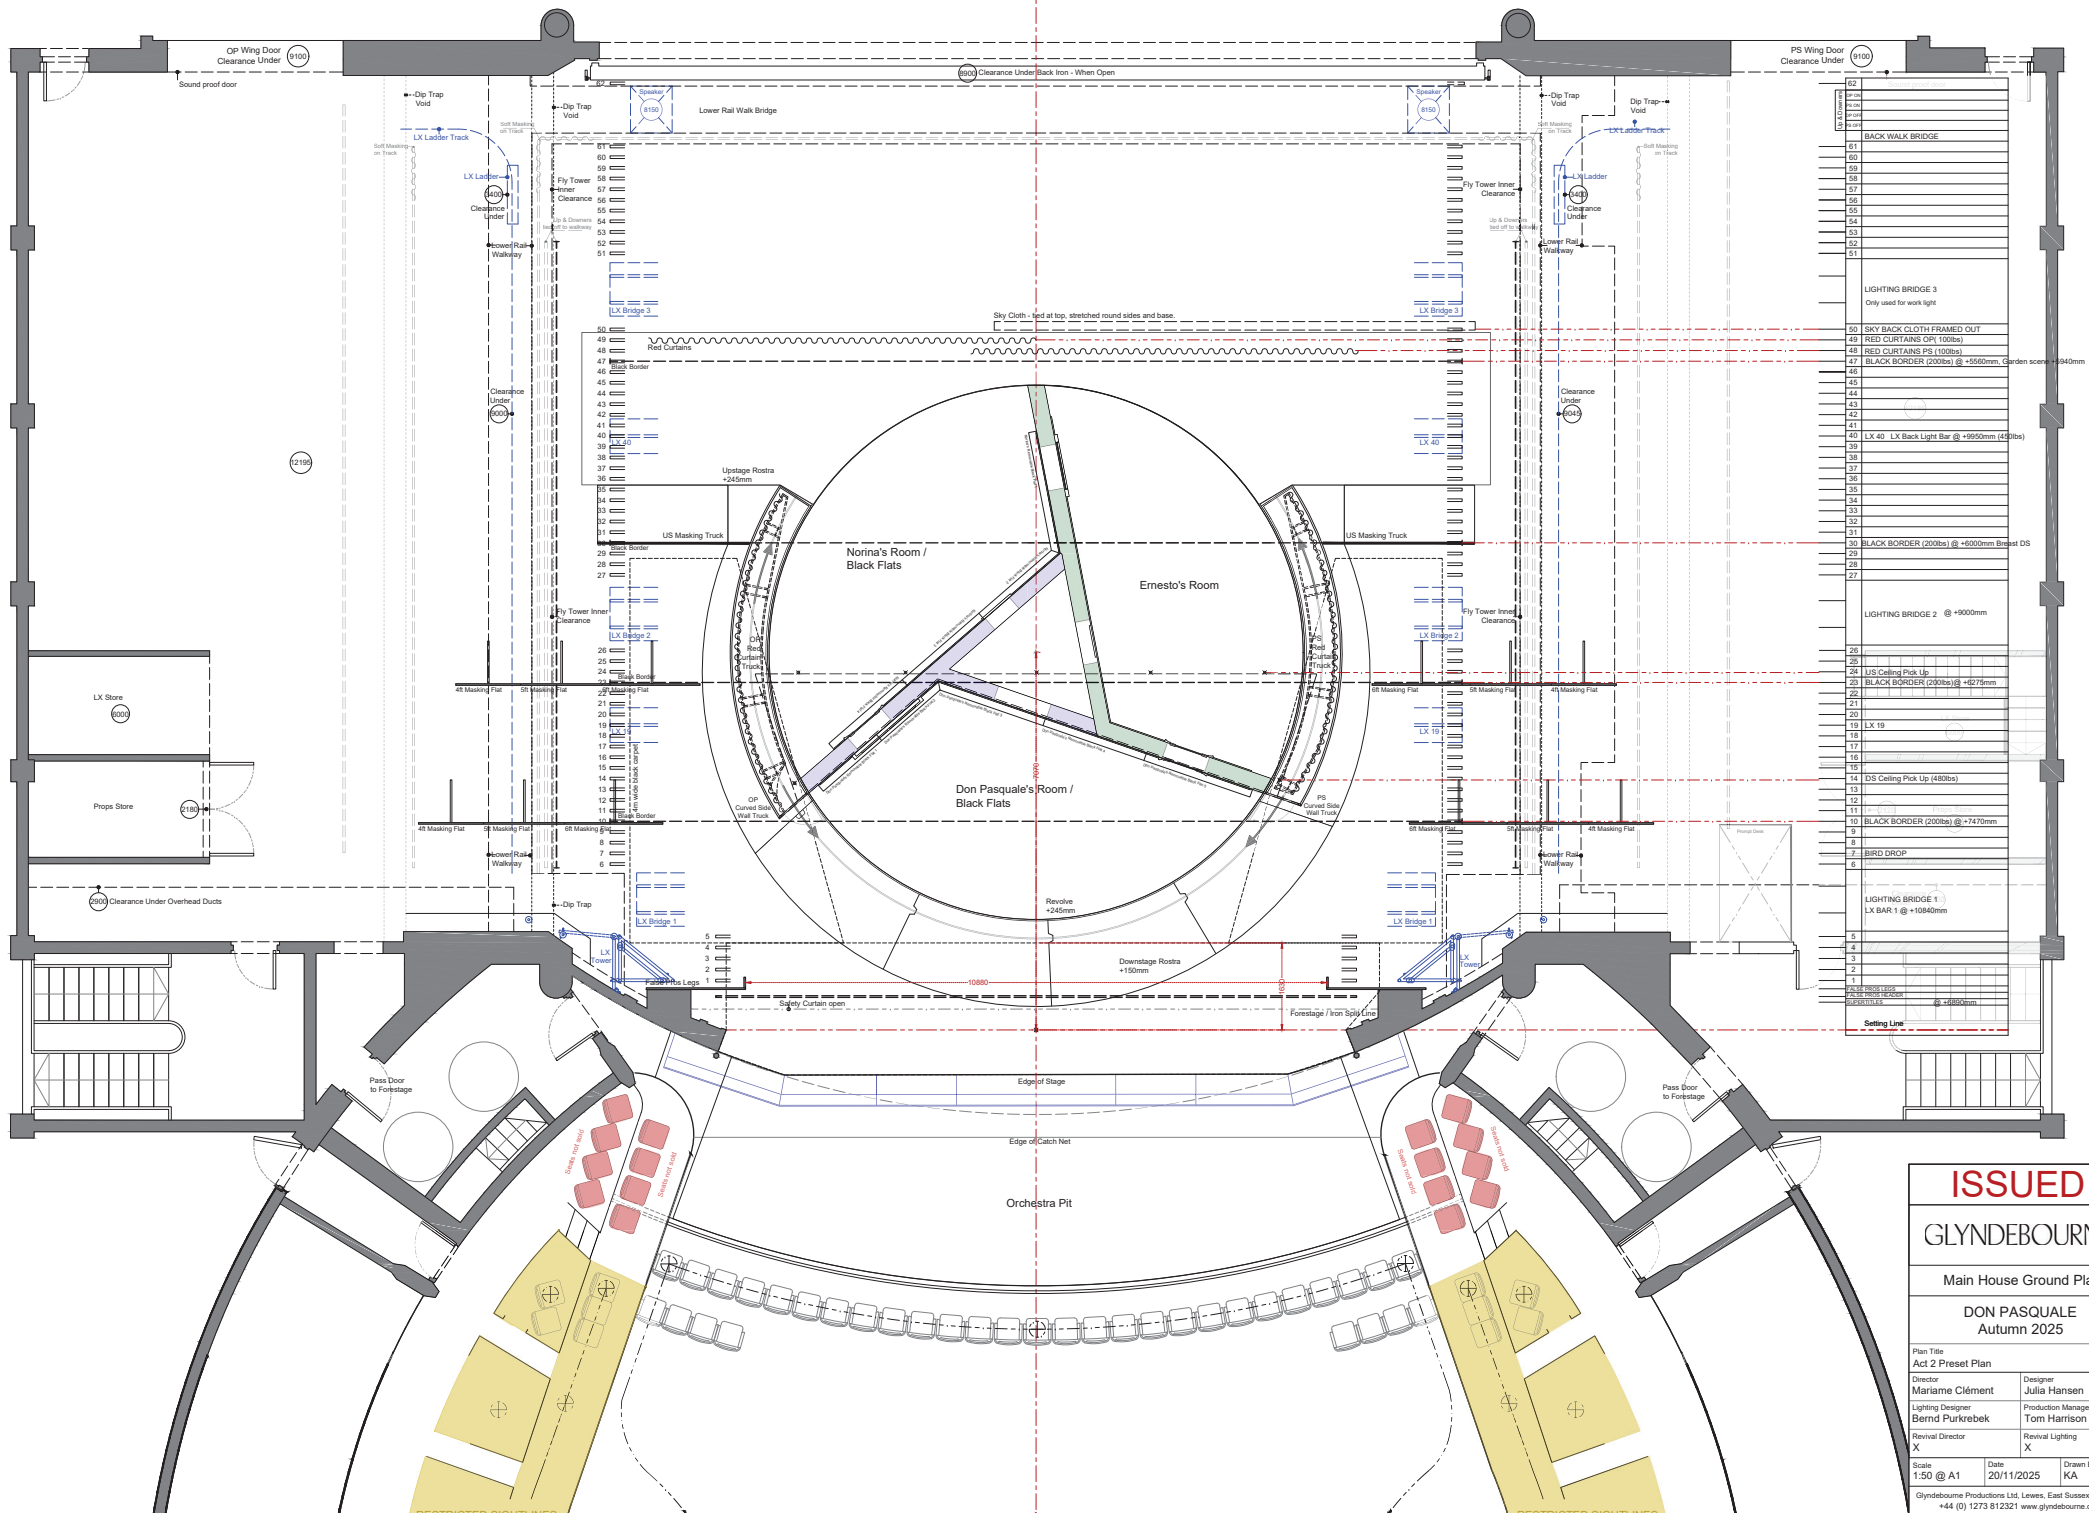

ISSUED

GLYNDEBOURNE

Main House Ground Plan

DON PASQUALE
Autumn 2025

Plan Title
Act 2 Preset Plan

Director
Mariane Clément

Lighting Designer
Bernd Purkrebek

Revival Director
X

Designer
Julia Hansen

Production Manager
Tom Harrison


Revival Lighting
X

Scale
1:50 @ A1

Date
20/11/2025

Drawn By
KA

Glyndebourne Productions Ltd, Lewes, East Sussex, BN9 5UJ
+44 (0) 1273 812321 www.glyndebourne.com

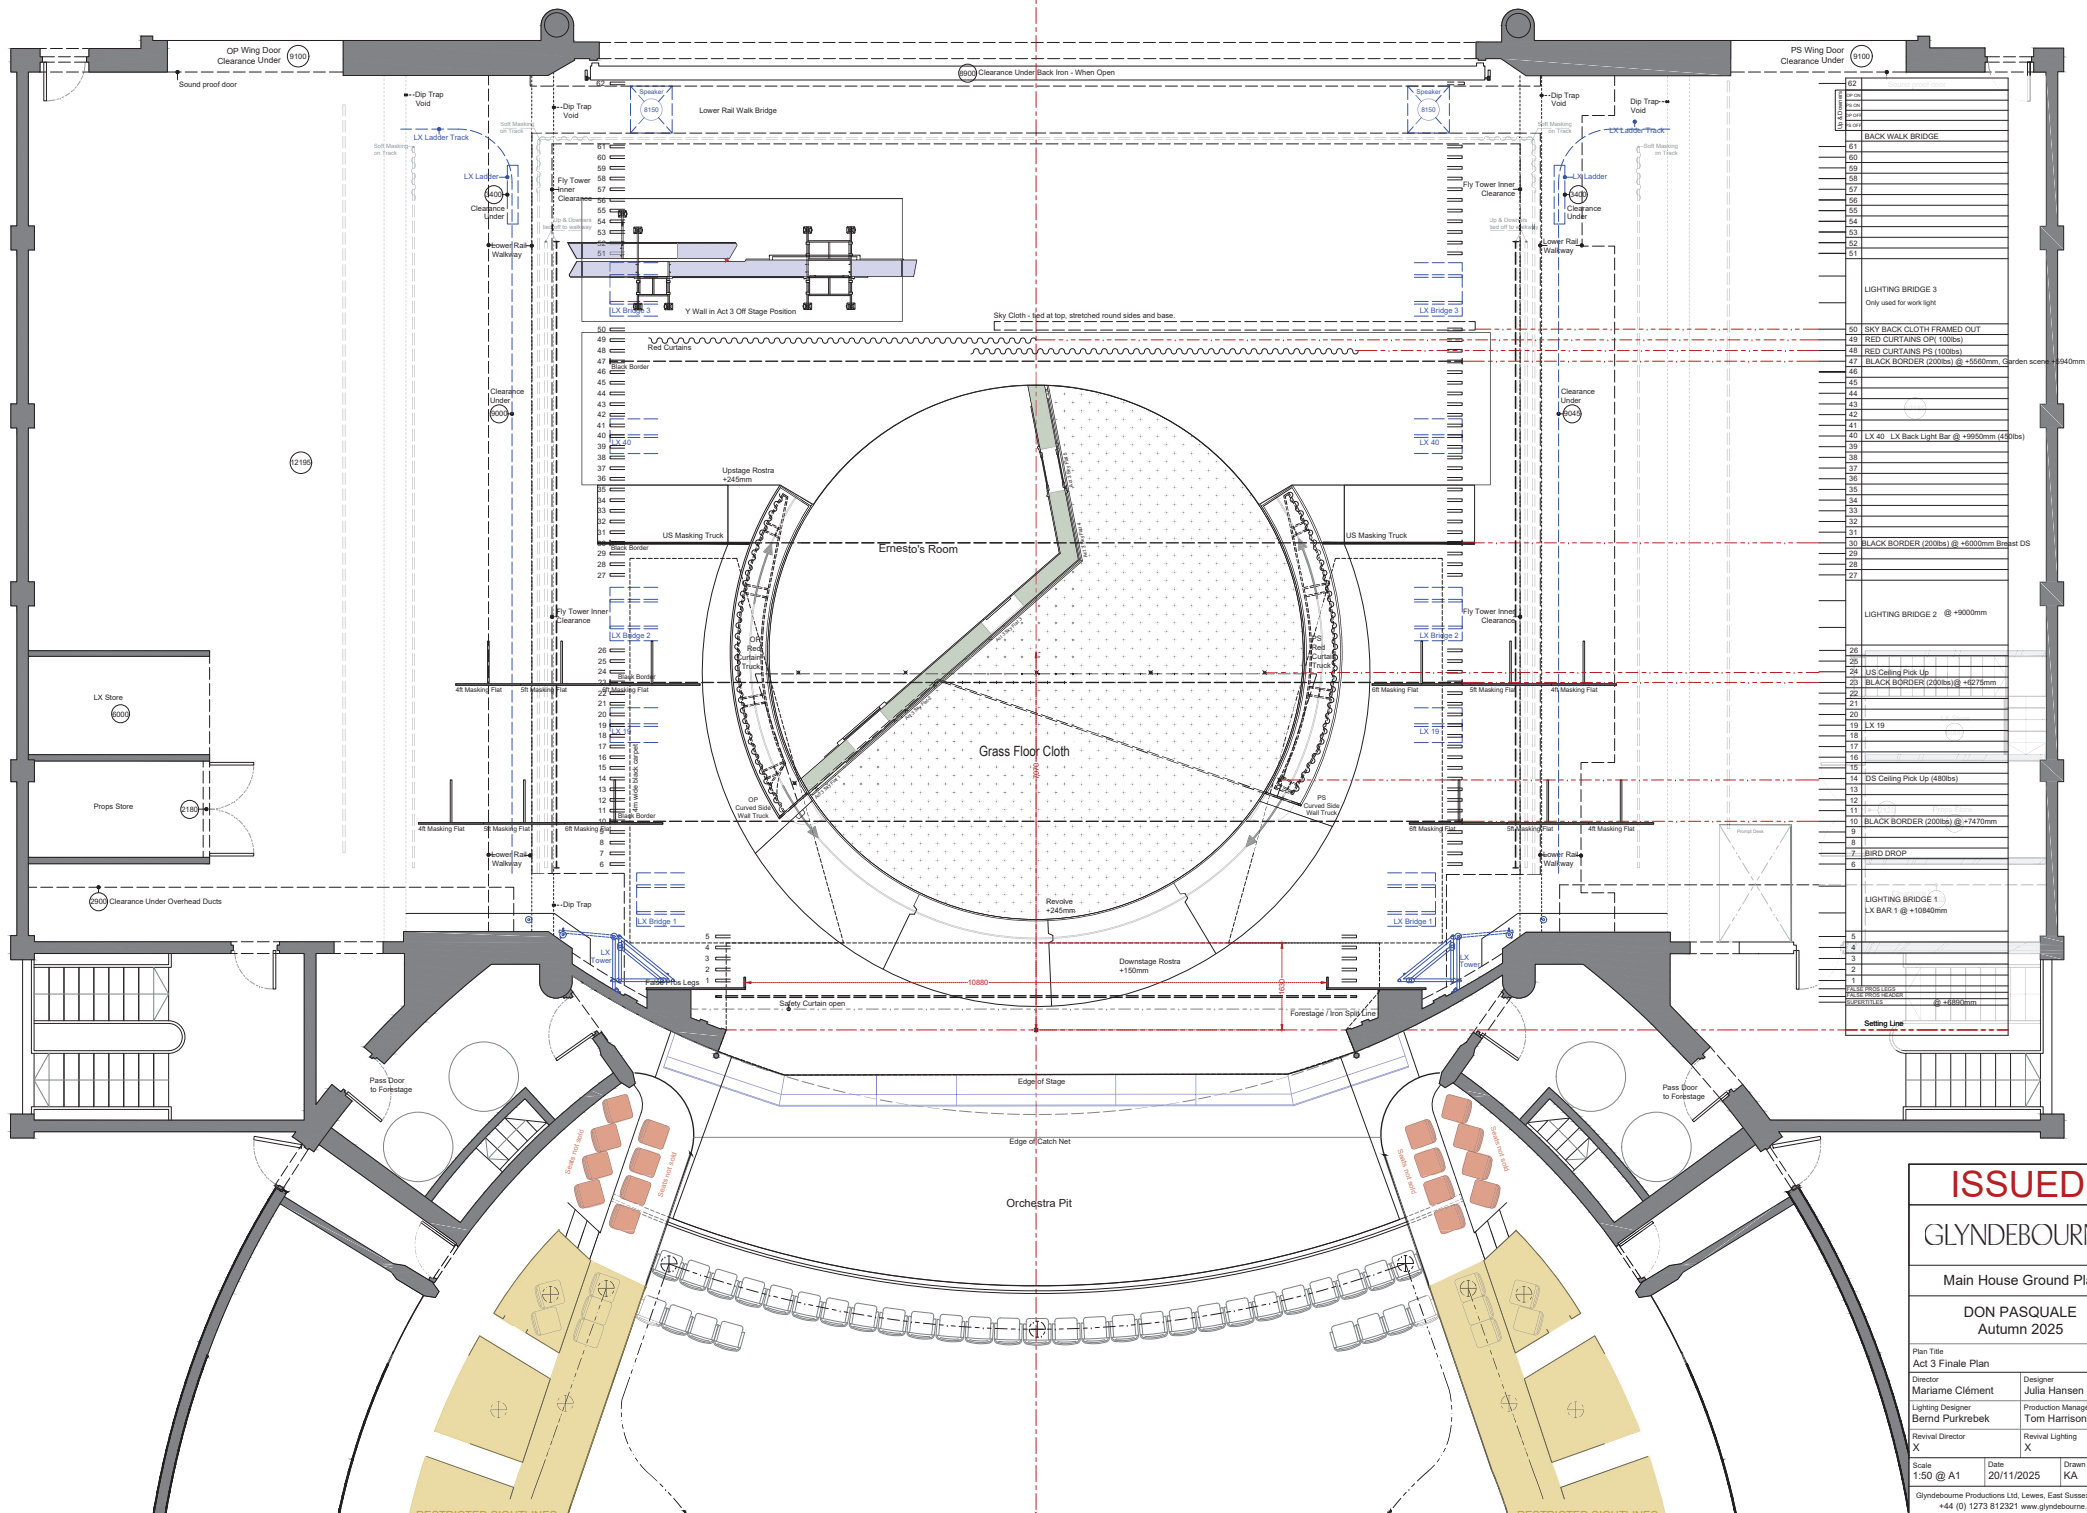

ISSUED

GLYNDEBOURNE

Main House Ground Plan

DON PASQUALE
Autumn 2025

Plan Title
Act 3 Finale Plan

Director
Marjorie Clément

Lighting Designer
Bernd Purkhebek

Revival Director
X

Designer
Julia Hansen

Production Manager
Tom Harrison

Revival Lighting
X

Scale
1:50 @ A1

Date
20/11/2025

Drawn By
KA

Glyndebourne Productions Ltd, Lewes, East Sussex, BN9 6UU

+44 (0) 1273 812321 www.glyndebourne.com